


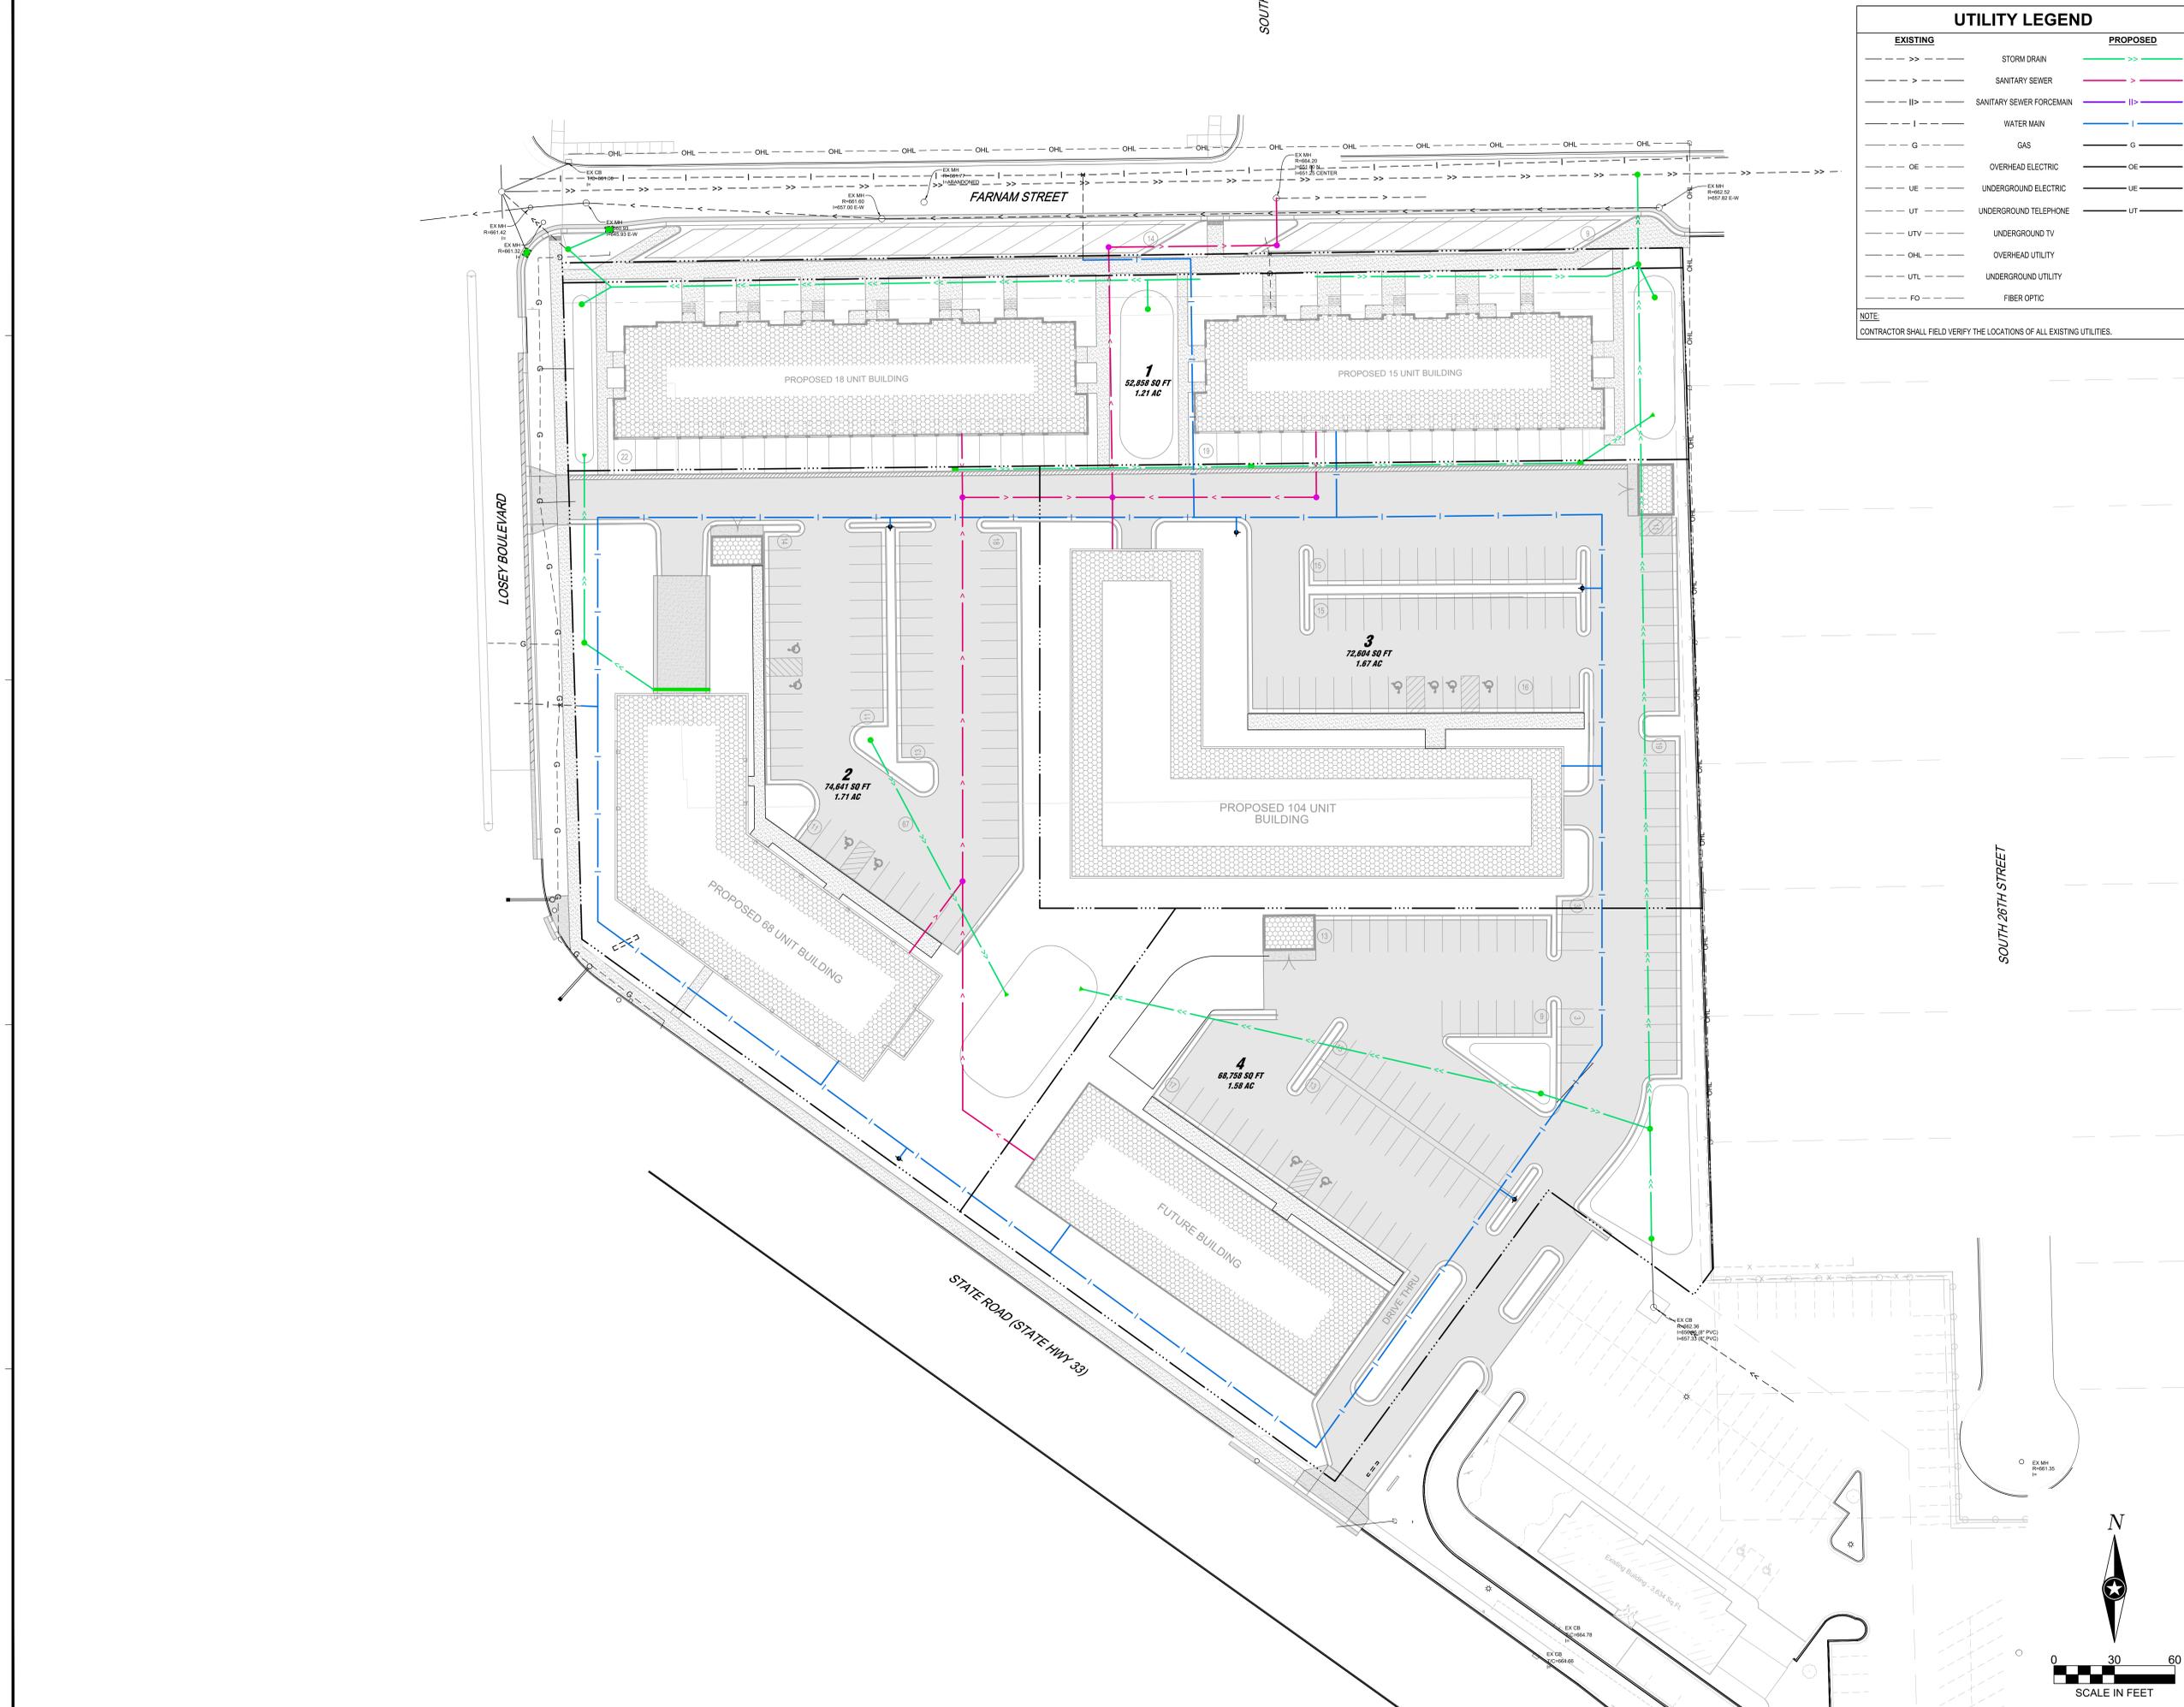

| UTILITY LEGEND | | |
|----------------|--------------------------|-----------|
| EXISTING | | PROPOSED |
| -->>--- | STORM DRAIN | --->>--- |
| ->--- | SANITARY SEWER | --->--- |
| - - | SANITARY SEWER FORCEMAIN | --- --- |
| - - - | WATER MAIN | --- - - |
| -G- - | GAS | ---G- - |
| -OE- - | OVERHEAD ELECTRIC | ---OE- - |
| -UE- - | UNDERGROUND ELECTRIC | ---UE- - |
| -UT- - | UNDERGROUND TELEPHONE | ---UT- - |
| -UTV- - | UNDERGROUND TV | ---UTV- - |
| -OHL- - | OVERHEAD UTILITY | ---OHL- - |
| -UTL- - | UNDERGROUND UTILITY | ---UTL- - |
| -FO- - | FIBER OPTIC | ---FO- - |

NOTE:
CONTRACTOR SHALL FIELD VERIFY THE LOCATIONS OF ALL EXISTING UTILITIES.



SHEET NOT VALID UNLESS THIS TEXT IS COLOR.
THIS DOCUMENT IS THE PROPERTY OF I & S GROUP, INC. AND MAY NOT BE USED, COPIED OR DUPLICATED WITHOUT PRIOR WRITTEN CONSENT.
© 2024 I & S GROUP, INC.

PROJECT
COPPER ROCKS DEVELOPMENT
LA CROSSE WISCONSIN

| REVISION SCHEDULE | | |
|-------------------|-------------|----|
| DATE | DESCRIPTION | BY |
| | | |
| | | |
| | | |

PROJECT NO. 31707
FILE NAME 31707 C3-UTILITY
DRAWN BY --
DESIGNED BY --
REVIEWED BY --
ORIGINAL ISSUE DATE --
CLIENT PROJECT NO. -

TITLE
UTILITY PLAN

SHEET
C3-20

PRELIMINARY NOT FOR CONSTRUCTION