




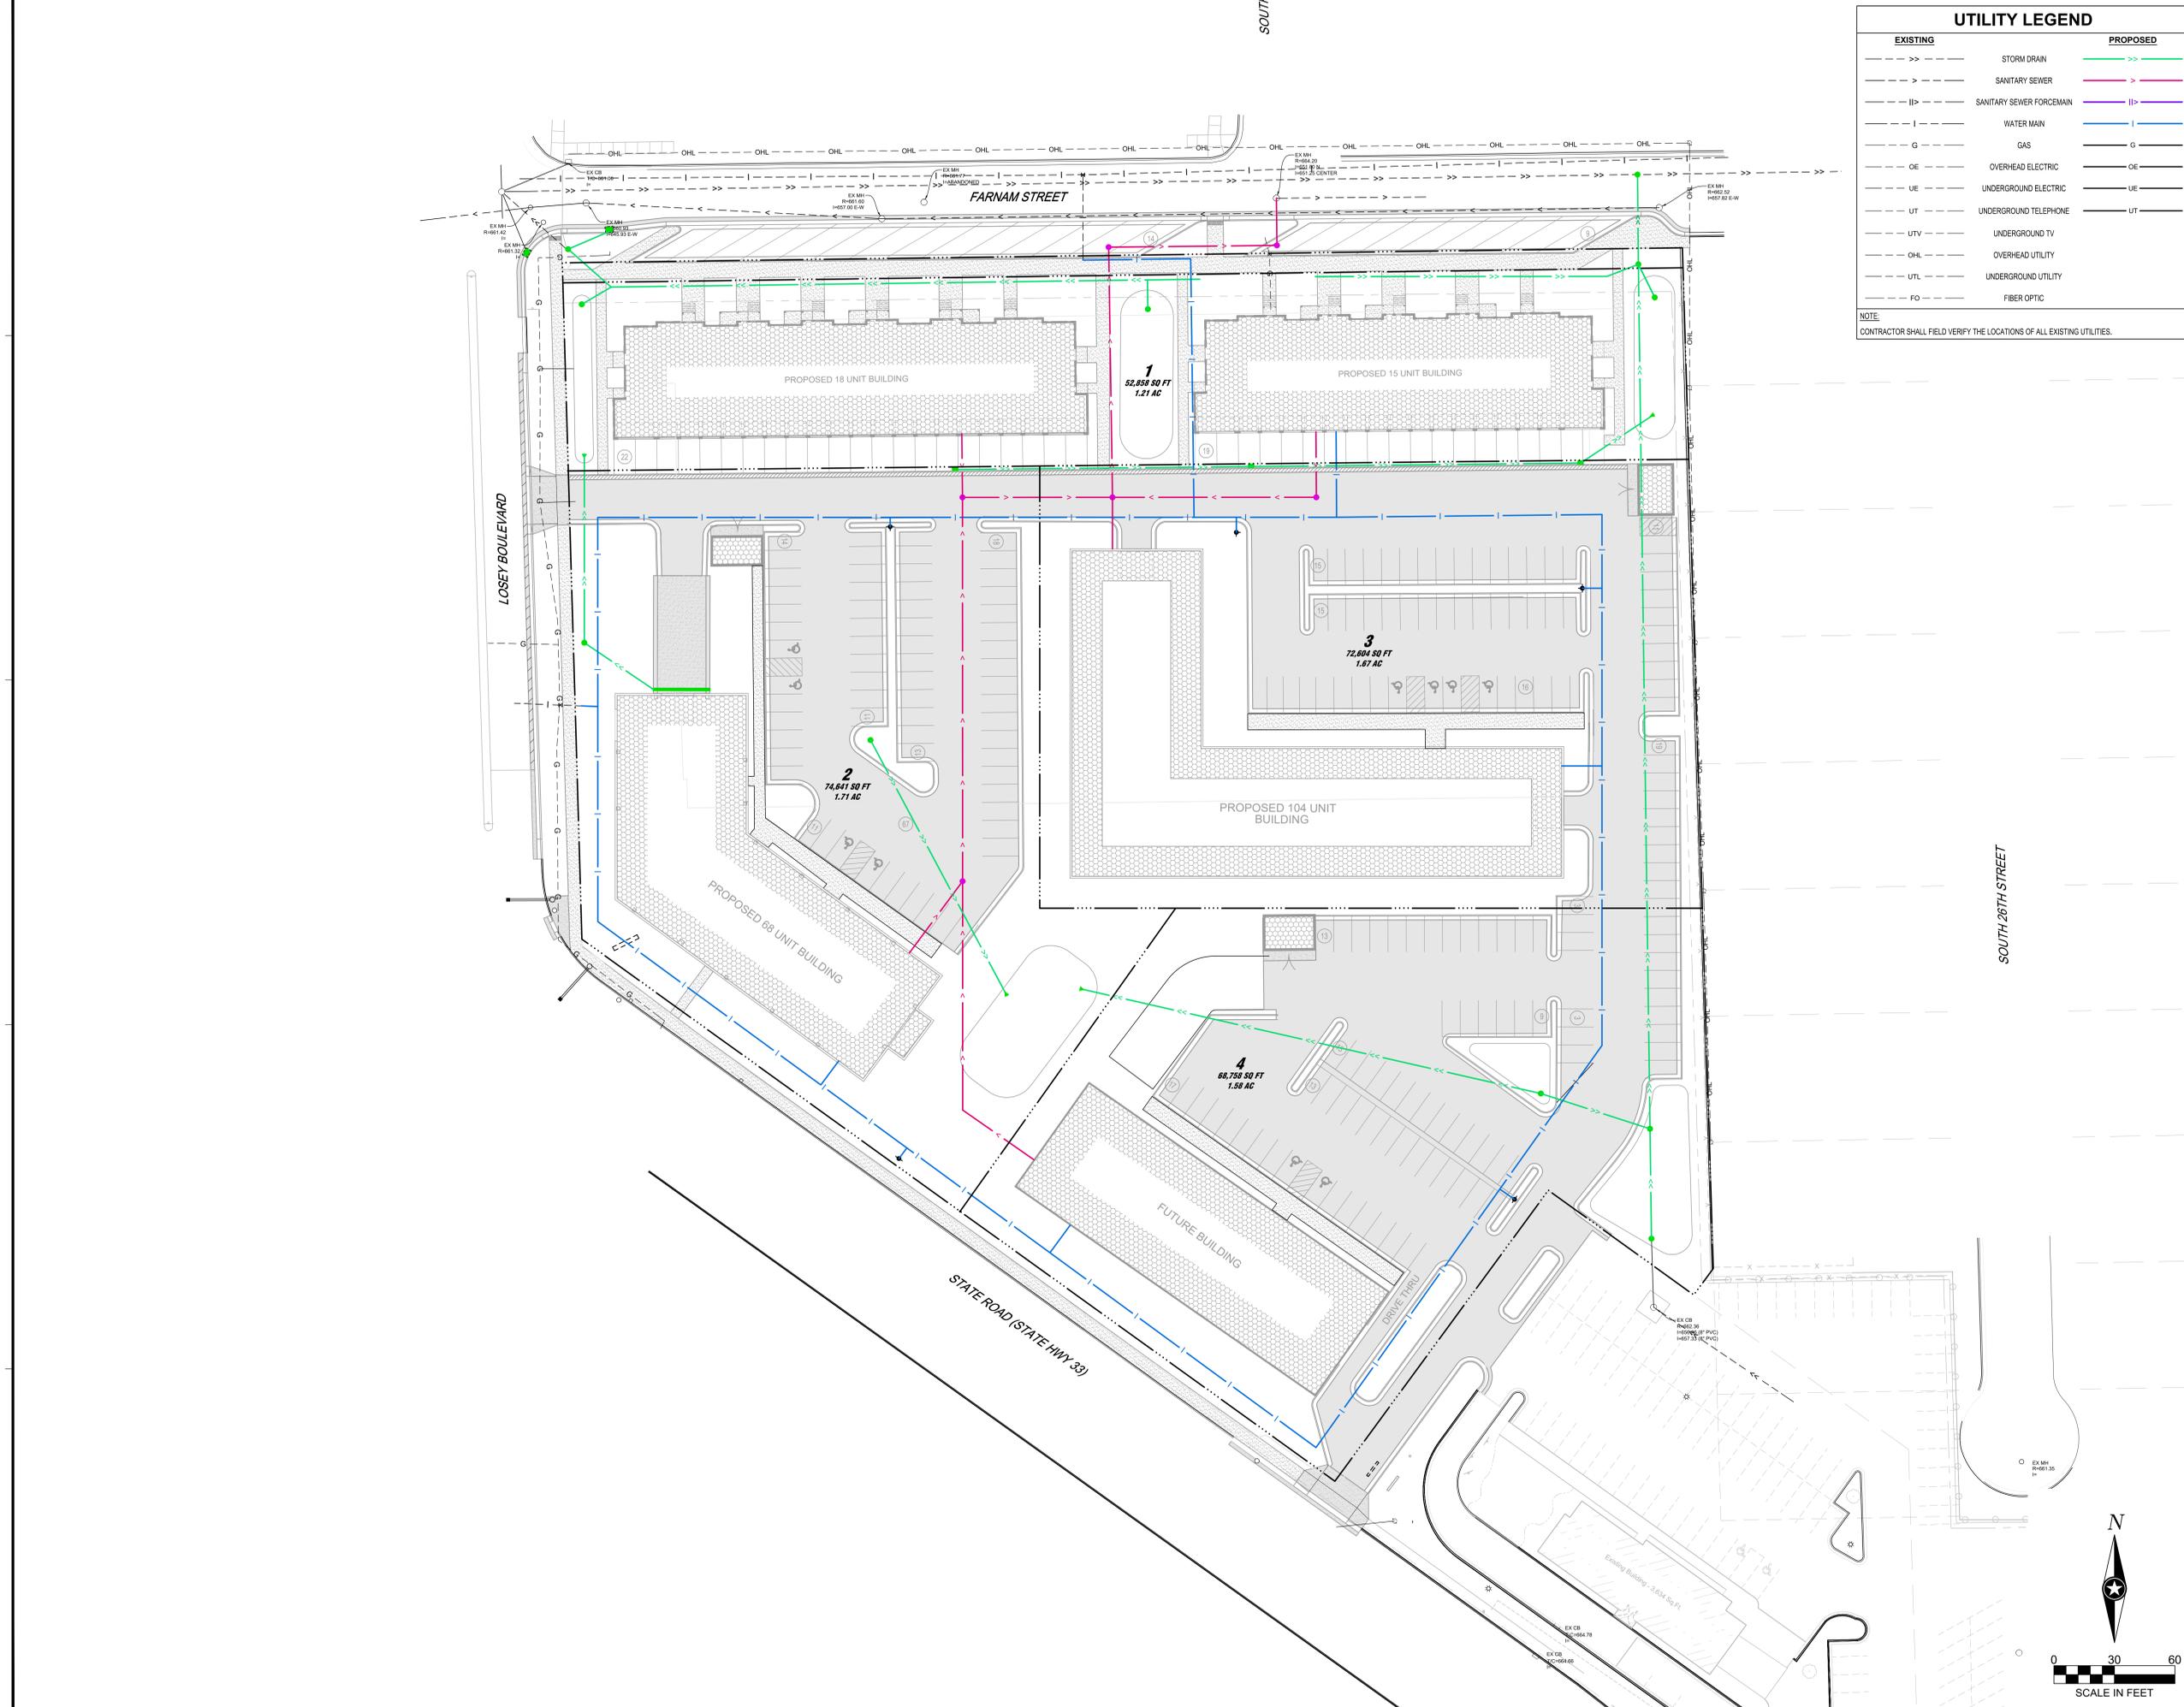

UTILITY LEGEND		
EXISTING		PROPOSED
->>->>-	STORM DRAIN	->>->>-
->->-	SANITARY SEWER	->->-
-  -  -	SANITARY SEWER FORCEMAIN	-  -  -
-I-I-	WATER MAIN	-I-I-
-G-G-	GAS	-G-G-
-OE-OE-	OVERHEAD ELECTRIC	-OE-OE-
-UE-UE-	UNDERGROUND ELECTRIC	-UE-UE-
-UT-UT-	UNDERGROUND TELEPHONE	-UT-UT-
-UTV-UTV-	UNDERGROUND TV	-UTV-UTV-
-OHL-OHL-	OVERHEAD UTILITY	-OHL-OHL-
-UTL-UTL-	UNDERGROUND UTILITY	-UTL-UTL-
-FO-FO-	FIBER OPTIC	-FO-FO-

NOTE:  
CONTRACTOR SHALL FIELD VERIFY THE LOCATIONS OF ALL EXISTING UTILITIES.



SHEET NOT VALID UNLESS THIS TEXT IS COLOR.  
THIS DOCUMENT IS THE PROPERTY OF I & S GROUP, INC. AND MAY NOT BE USED, COPIED OR DUPLICATED WITHOUT PRIOR WRITTEN CONSENT.  
© 2024 I & S GROUP, INC.

PROJECT  
**COPPER ROCKS DEVELOPMENT**  
LA CROSSE WISCONSIN

REVISION SCHEDULE		
DATE	DESCRIPTION	BY

PROJECT NO. 31707  
FILE NAME 31707 C3-UTILITY  
DRAWN BY --  
DESIGNED BY --  
REVIEWED BY --  
ORIGINAL ISSUE DATE --  
CLIENT PROJECT NO. --

TITLE  
**UTILITY PLAN**

SHEET  
**C3-20**

PRELIMINARY NOT FOR CONSTRUCTION PRELIMINARY NOT FOR CONSTRUCTION